


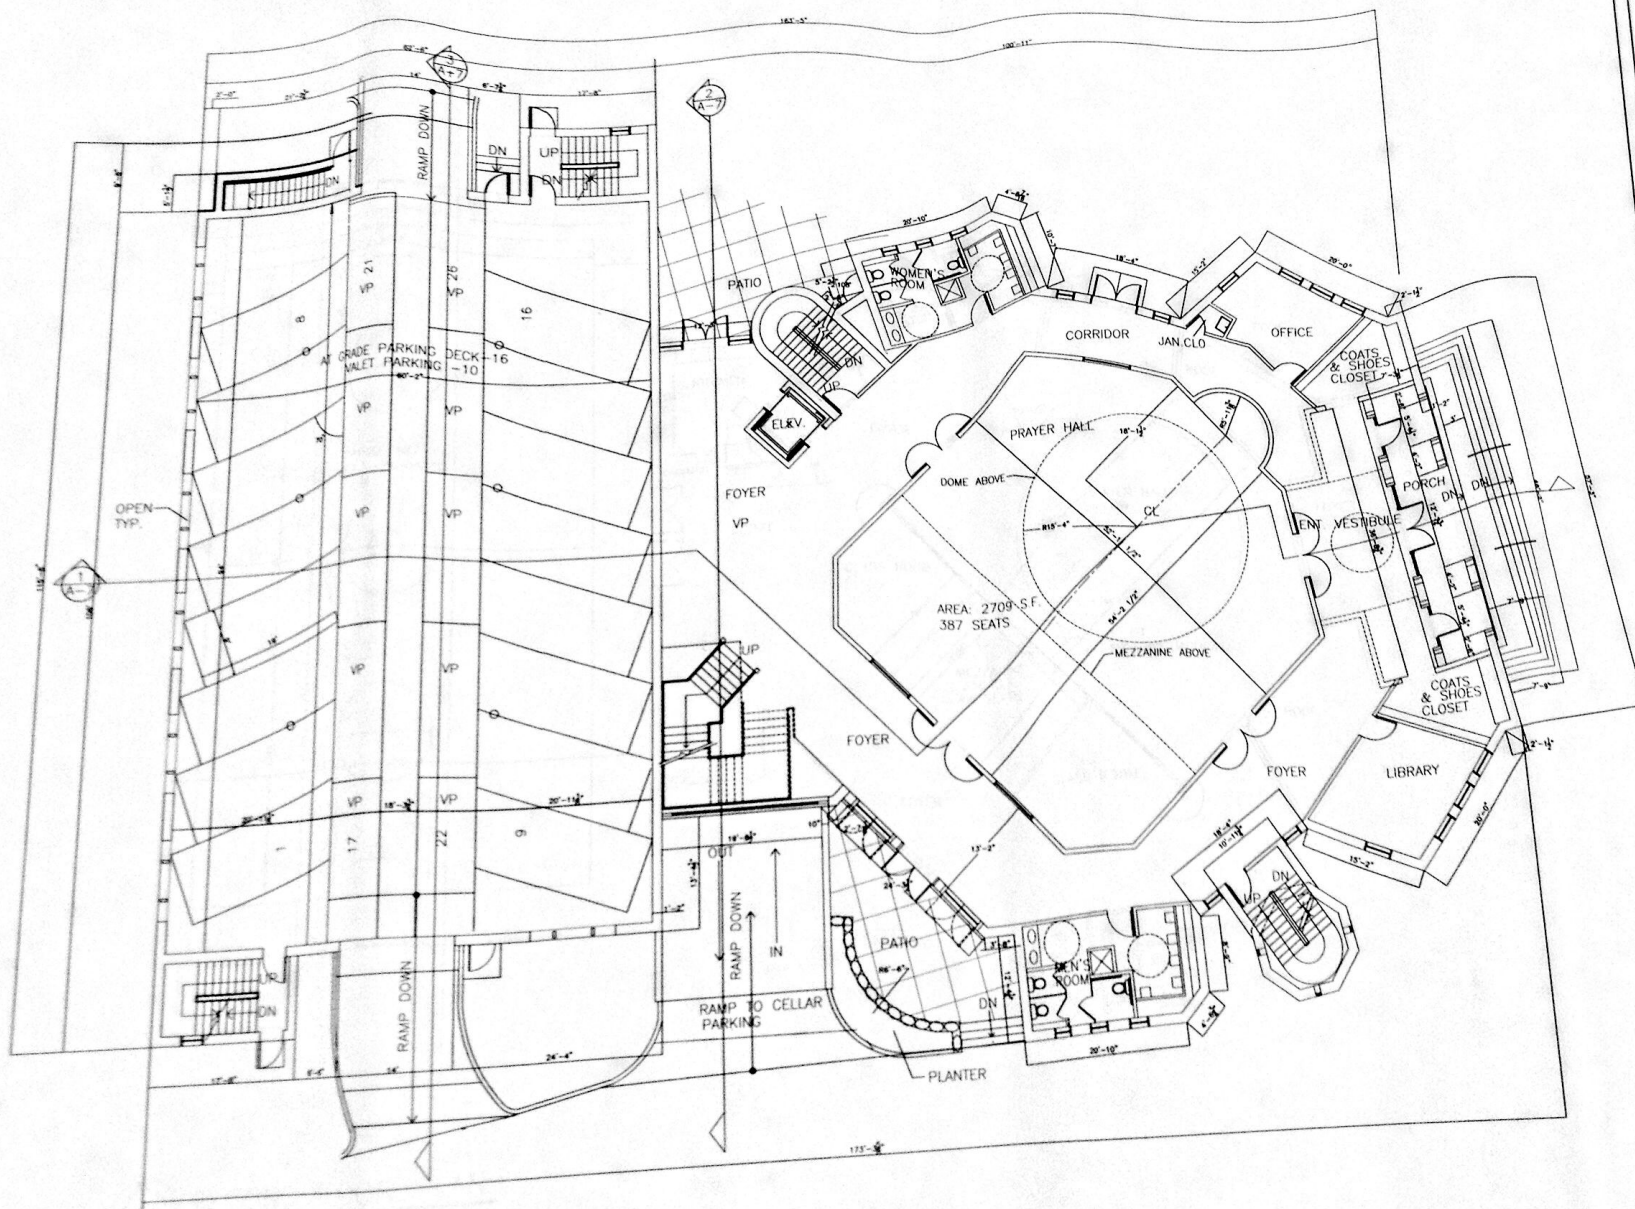

SA ARCHITECTS, LLC

Architecture, Interior Design
and Construction Management
28 Spilltruck road
Norwalk, Connecticut 06854
203-854-6753

Settlement Drawing Documents
Submitted August 18, 2014

REVISIONS				
NO.	BY	DATE	DESCRIPTION	
1	SA	8-11-2014	PLANNING AND ZONING SUBMISSION	
2	SA	12-21-2014	PLANNING & ZONING RE-SUBMISSION	
3	SA	1-28-2014	PLANNING & ZONING RE-SUBMISSION CORRIDOR/PAVILION PORCH ROOM REVISIONS	

PROJECT TITLE


**PROPOSED
ALMADNY
ISLAMIC CENTER
OF NORWALK
AT 127 FILLOW ST.
NORWALK, CT**

SHEET TITLE

FIRST FLOOR PLAN

DESIGN BY: SAU
PROJECT NUMBER: 120

SCALE: 1/8"=1'-0"
DATE: APRIL 20, 2008

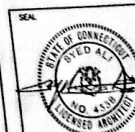

SHEET NUMBER

A-2

FIRST FLOOR PLAN
SCALE: 1/8"=1'-0"